



Evans, Mechwart, Hambleton & Tilton, Inc.
 Engineers • Surveyors • Planners • Scientists
 5500 New Albany Road, Columbus, OH 43054
 Phone: 614.775.4500 Toll Free: 888.775.3648
 emht.com

CITY OF COLUMBUS, FRANKLIN COUNTY, OHIO
 CIP # 650870-100002
 FOR


WEISHEIMER/INDIAN SPRINGS

MH#0298S0216 MH#0298S0217
 199 SCHREYER PLACE PREMISE #1196388
 LATERAL REHABILITATION PLAN

DATE: July, 2014

SCALE: 1" = 10'

JOB NO.: 2013-0603

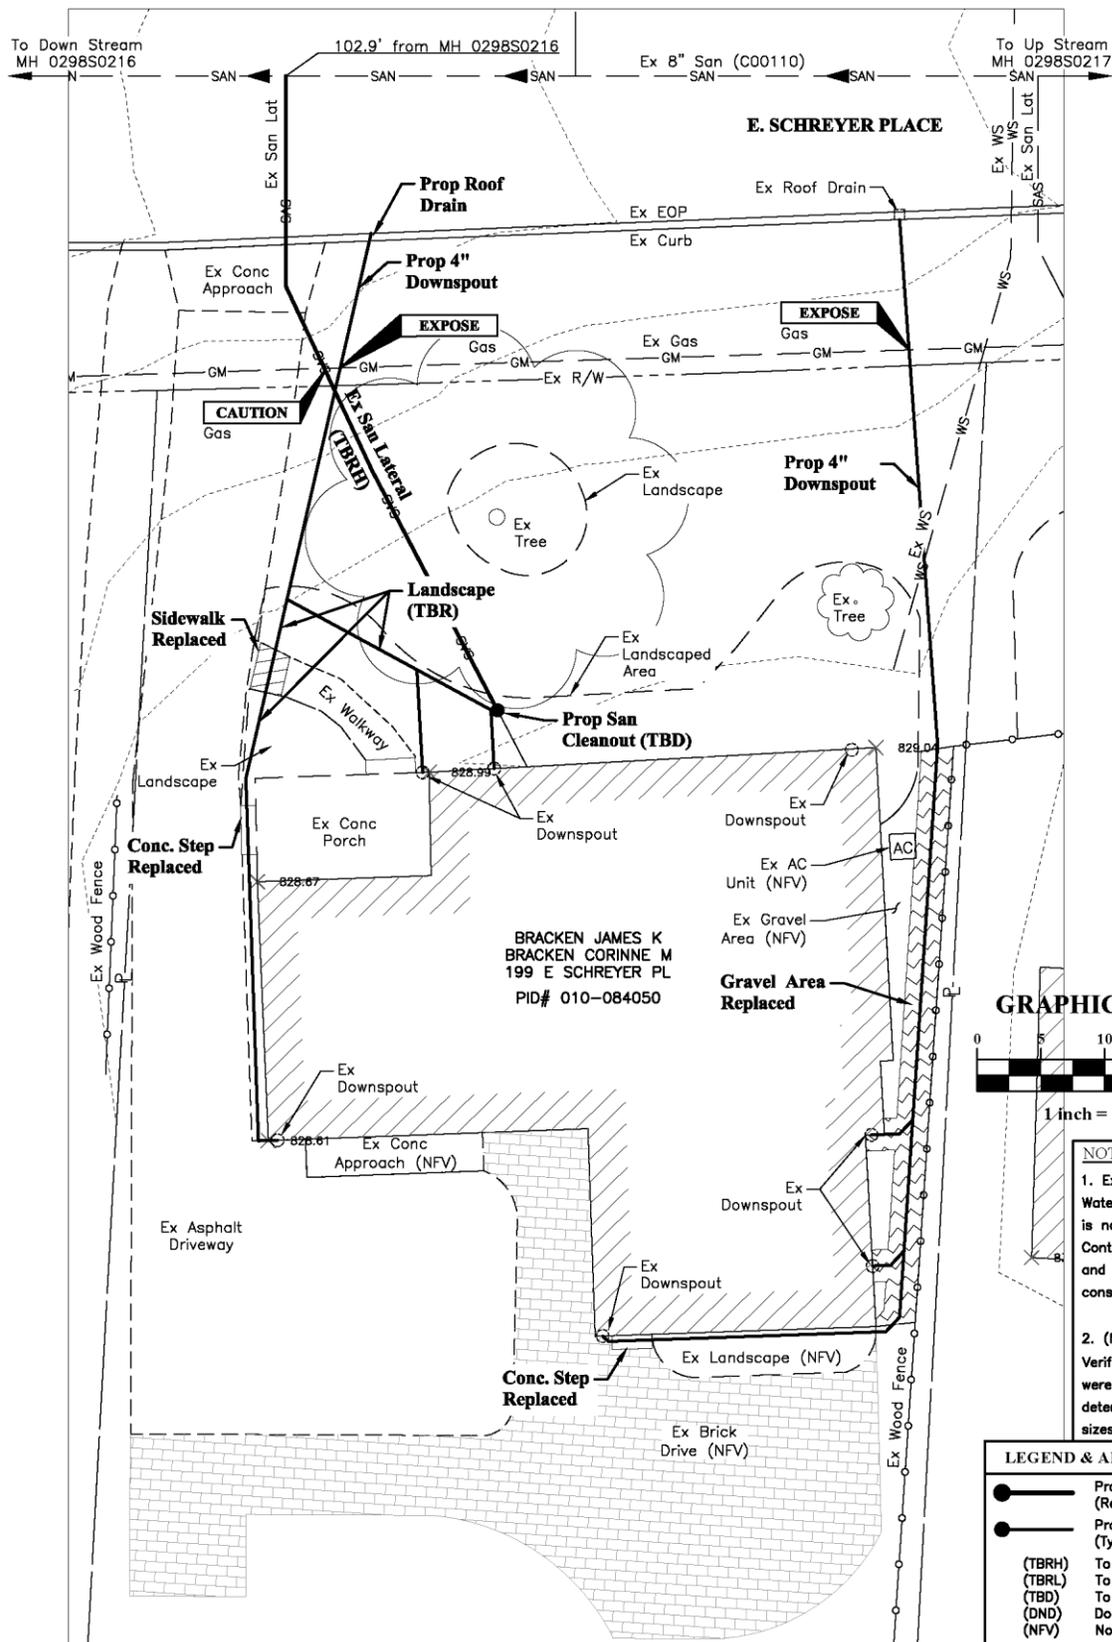

NOTE:
 1. Exact location of Water and Gas Services is not known. Contractor shall locate and EXPOSE prior to construction.
 2. (NFV) = Not Field Verified. Exact locations were not surveyed to determine locations & sizes.

LEGEND & ABBREVIATIONS

- Prop Sanitary Lateral (Rehabilitated)
- Prop 4" Downspout (Typical)
- (TBRH) To Be Rehabilitated
- (TBRL) To Be Relocated
- (TBD) To Be Determined
- (DND) Do Not Disturb
- (NFV) Not Field Verified

ESTIMATE OF QUANTITIES

Ref	Item No.	Quantity	Unit	Description
1	SS-12	54	LF	6" Lateral CIPP
2	202	1	LS	Landscape Remove & Replace
3	202	14	SY	Gravel Remove & Replace
4	605	265	LF	4" Solid Wall PVC
5	608	9	SF	Sidewalk
6	659	148	SY	Seeding & Mulching
7	915	1	Ea	Cleanout
8	SPEC	7	Ea	Downspout Connections

J:\20130603\Drawings\Sanitary Plan\schreyer.pl\0298S0216-0298S0217 South Schreyer Pl.dwg Last Saved By: mbarga, 7/2/2014 10:55 AM Last Printed By: Barco, Mark, 7/2/2014 10:55 AM (No Xrefs)




CITY OF COLUMBUS, FRANKLIN COUNTY, OHIO
 CIP # 650870-100002
 FOR
WEISHEIMER/INDIAN SPRINGS
 MH#0298S0156 MH#0298S0154
 291 WEISHEIMER ROAD PREMISE #1230482
LATERAL REHABILITATION PLAN

DATE: June, 2014

SCALE: 1" = 10'

JOB NO.: 2013-0603


\\cmhdata01\project01\20130603\Drawings\Sanitary Plan\Weisheimer Rd\0298S0156-0298S0154 - 291 WEISHEIMER ROAD.dwg Last Saved By: csummers, 6/5/2014 2:46 PM Last Printed By: Summers, Corey, 6/5/2014 2:46 PM (No Xrefs)

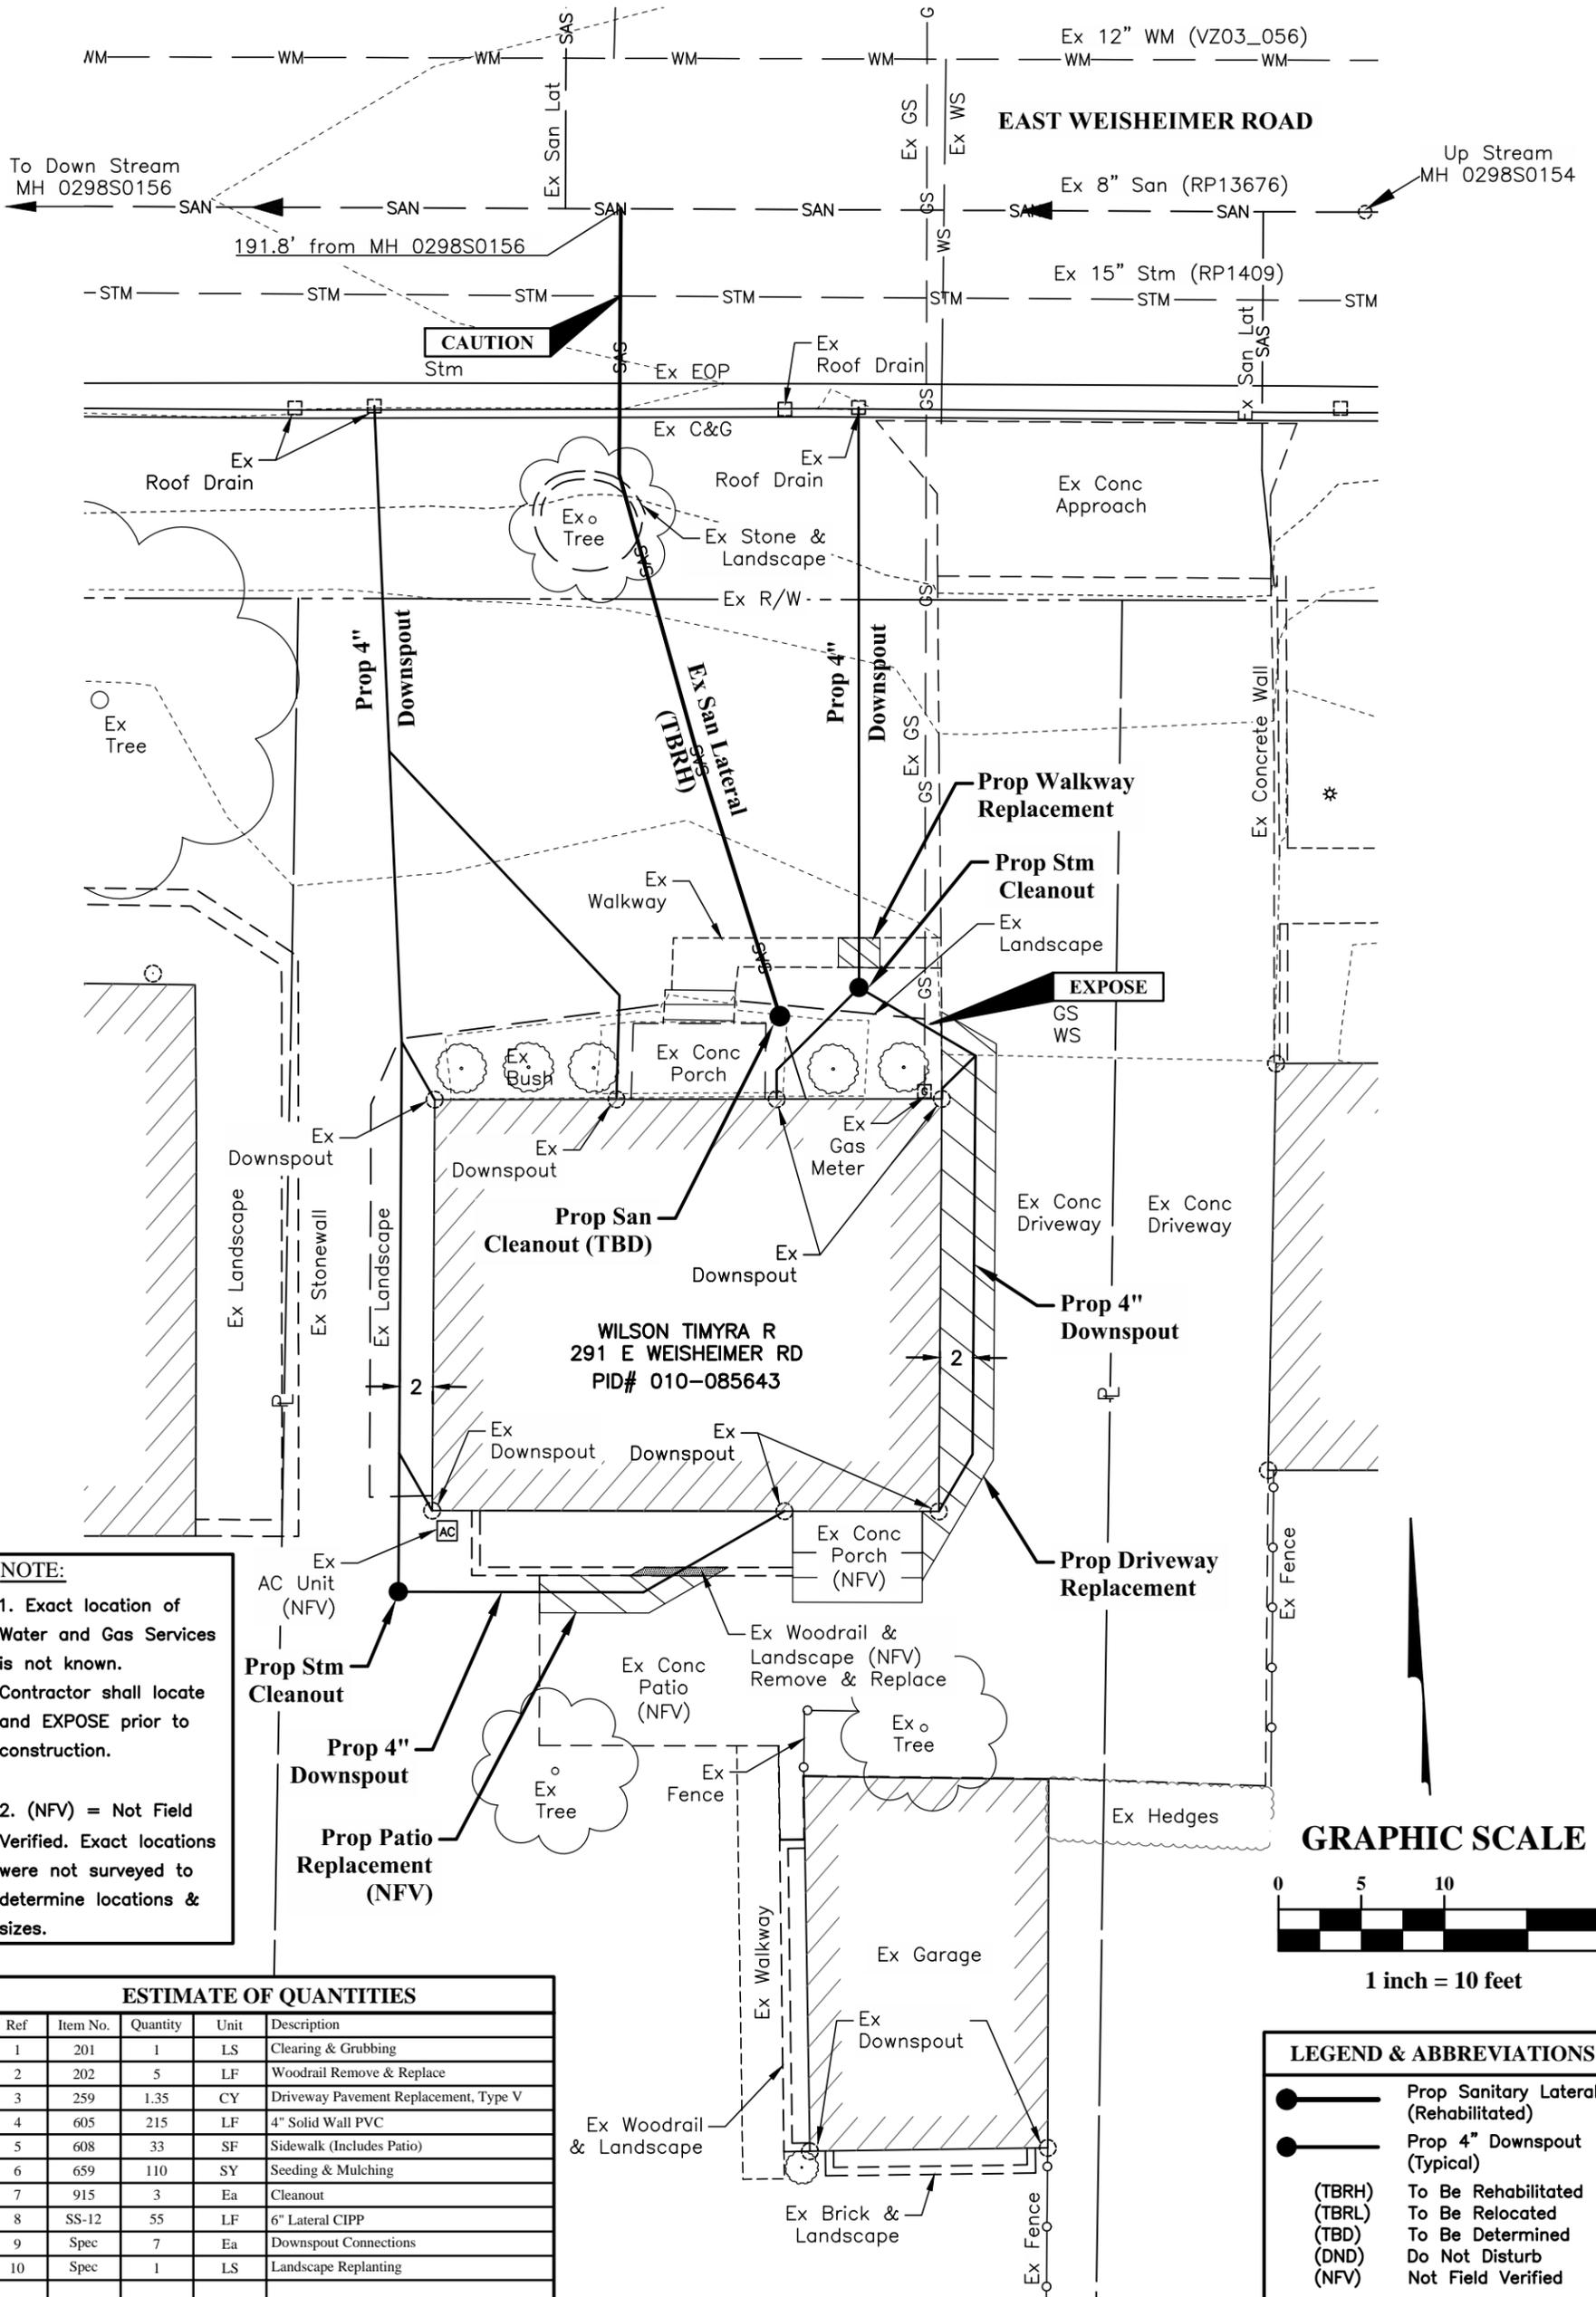

NOTE:

- Exact location of Water and Gas Services is not known. Contractor shall locate and EXPOSE prior to construction.
- (NFV) = Not Field Verified. Exact locations were not surveyed to determine locations & sizes.

ESTIMATE OF QUANTITIES				
Ref	Item No.	Quantity	Unit	Description
1	201	1	LS	Clearing & Grubbing
2	202	5	LF	Woodrail Remove & Replace
3	259	1.35	CY	Driveway Pavement Replacement, Type V
4	605	215	LF	4" Solid Wall PVC
5	608	33	SF	Sidewalk (Includes Patio)
6	659	110	SY	Seeding & Mulching
7	915	3	Ea	Cleanout
8	SS-12	55	LF	6" Lateral CIPP
9	Spec	7	Ea	Downspout Connections
10	Spec	1	LS	Landscape Replanting

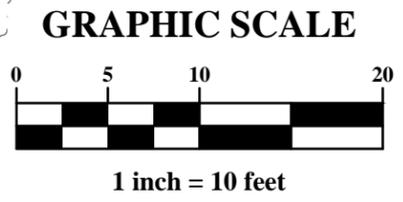

LEGEND & ABBREVIATIONS	
	Prop Sanitary Lateral (Rehabilitated)
	Prop 4" Downspout (Typical)
(TBRH)	To Be Rehabilitated
(TBRL)	To Be Relocated
(TBD)	To Be Determined
(DND)	Do Not Disturb
(NFV)	Not Field Verified